


Luminaire schedule						
DESCRIPTION	MANUFACTURER/MODEL #	VOLTAGE	LAMPS	REMARKS		
POST TOP MOUNTED LED ACORN FIXTURE ON 12'-6" FLUTED POLE	HADCO: FIXTURE *CII540, BANNER ARM *CAII540A, POLE *CPII540A	277	LEDS FURNISHED	WITH BASE MOUNTED TRANSFORMER AND FUSE HOLDERS FOR RECEPTACLE. REFER 1/EL2.02 FOR POLE BASE DETAIL		
SAME AS TYPE 'SA' EXCEPT W/ TWIN SIDED BANNER ARMS	HADCO: FIXTURE *CII540, (2) BANNER ARMS *CAII540A, POLE *CPII540A	277	LEDS FURNISHED	WITH BASE MOUNTED TRANSFORMER AND FUSE HOLDERS FOR RECEPTACLE, REFER 1/EL2.02 FOR POLE BASE DETAIL		
ARM MOUNTED LED ACORN FIXTURE @ 16'-0" A.F.G. ON 25'-0" FLUTED POLE	HADCO: FIXTURE *CII540, (2) BANNER ARMS *CAII540A, POLE *CPII540B MOD W/ *CAII540B ARM BRACKET	277	LEDS FURNISHED	WITH BASE MOUNTED TRANSFORMER AND FUSE HOLDERS FOR RECEPTACLE, REFER 1/EL2.02 FOR POLE BASE DETAIL		
FESTOON LIGHTS ANCHORED TO EYE BOLT AT TOP OF '52' POLES	TOKISTAR "EXBK-12-WW-F (MOUNTING) "EX-MDA-BK (POWER SUPPLY) "T24-300	24∨.	FURNISHED	PROVIDE WITH 1/8" ROUND AIRCRAFT CANTENARY CABLE		
SAME AS TYPE 'SA' EXCEPT W/ DUPLEX RECEPTACLE W/ IN-USE COVER AT POLE BASE ABOVE HAND HOLE FOR VENDOR POWER		277				
	POST TOP MOUNTED LED ACORN FIXTURE ON 12'-6" FLUTED POLE  SAME AS TYPE 'SA' EXCEPT W/ TWIN SIDED BANNER ARMS  ARM MOUNTED LED ACORN FIXTURE ® 16'-0" AFG. ON 25'-0" FLUTED POLE  FESTOON LIGHTS ANCHORED TO EYE BOLT AT TOP OF 'S2' POLES  SAME AS TYPE 'SA' EXCEPT W/ DUPLEX RECEPTACLE W/ IN-USE COVER AT POLE BASE ABOVE	POST TOP MOUNTED LED ACORN FIXTURE ON 12'-6" FLUTED POLE  SAME AS TYPE 'SA' EXCEPT W/ TWIN SIDED BANNER ARMS  ARM MOUNTED LED ACORN FIXTURE OF IS'-0" AFG. ON 25'-0" FLUTED POLE  FESTOON LIGHTS ANCHORED TO EYE BOLT AT TOP OF 'S2' POLES  SAME AS TYPE 'SA' EXCEPT W/ DUPLEX RECEPTACLE W/ IN-USE COVER AT POLE BASE ABOVE  HADCO: FIXTURE *CII540, (2) BANNER ARMS *CAII540A, POLE *CPII540B MOD W/ *CAII540B *CAII540A, POLE *CPII540B *CAII540A, PO	DESCRIPTION  MANUFACTURER/MODEL #  POST TOP MOUNTED LED ACORN FIXTURE ON 12'-6" FLUTED POLE  SAME AS TYPE 'SA' EXCEPT W/ TWIN SIDED BANNER ARMS  ARM MOUNTED LED ACORN FIXTURE **CII540, (2) BANNER ARMS  "CAII540A, POLE **CPII540A  211  ARM MOUNTED LED ACORN FIXTURE **CII540, (2) BANNER ARMS  "CAII540A, POLE **CPII540A  ARM MOUNTED LED ACORN FIXTURE **CII540, (2) BANNER ARMS  "CAII540A, POLE **CPII540B MOD W/ **CAII540B ARM BRACKET  FESTOON LIGHTS ANCHORED TO EYE BOLT AT TOP OF 'S2' POLES  SAME AS TYPE 'SA' EXCEPT W/ DUPLEX RECEPTACLE W/ IN-USE COVER AT POLE BASE ABOVE  ARM BRACKET  TOKISTAR **EXBK-12-WW-F (MOUNTING) **EX-MDA-BK (POWER SUPPLY) **T24-300  24V.	DESCRIPTION  MANUFACTURER/MODEL #  VOLTAGE  LAMPS  POST TOP MOUNTED LED ACORN FIXTURE ON 12'-6" FLUTED POLE  SAME AS TYPE 'SA' EXCEPT W/ TWIN SIDED BANNER ARMS  ARM MOUNTED LED ACORN FIXTURE  (CAII540A, POLE CPII540A  ARM MOUNTED LED ACORN FIXTURE (CAII540A, POLE CPII540A  ARM MOUNTED LED ACORN FIXTURE (CAII540A, POLE CPII540B MOD W/ CAII540B  ARM BRACKET  FESTOON LIGHTS ANCHORED TO EYE BOLT AT TOP OF 'S2' POLES  SAME AS TYPE 'SA' EXCEPT W/ DUPLEX RECEPTACLE W/ IN-USE COVER AT POLE BASE ABOVE  MANUFACTURER/MODEL #  VOLTAGE  LAMPS  LEDS FURNISHED  11  LEDS FURNISHED  211  LEDS FURNISHED  12  TOKISTAR EXBK-12-UW-F (MOUNTING) EX-MDA-BK (POWER SUPPLY) T24-300  24V. FURNISHED		

	ELECTRICAL SYMBOL LEGEND NOTE: NOT ALL SYMBOLS APPEAR ON ALL DRAWINGS							
SYMBOL	DESCRIPTION	SYMBOL	DESCRIPTION					
<b>←⊕•</b> 0→	Pole/Arm Mounted Area Light (Arrow Denotes Banner W/ Twin Sided Banner Arms Arm Orientation)	<b>#</b>	Flush in Wall Duplex Receptacle					
⊕→	Post Top Mounted Area Light W/ (Arrow Denotes Banner Single Sided Banner Arms Arm Orientation)	<b>⊕</b> GFCI	Flush In Wall Duplex Receptacle - Ground Fault Circuit Interrupt					
	String Lights	FC	Timeclock					
	Conduit In Or Under Floor / Grade	РС	Photocell					
	Homerun To Panelboard in Or Under Floor / Grade		Surface Mounted Branch Circuit Panel					
<del>  </del>	Wire Run Indicating Ground Wire, Phase And Neutral Conductors	Ų	Fused Disconnect Switch					
J	Junction Box Flush With Grade	T	Transformer					
		WP	Weatherproof					

EXISTING UTILITY POLE -

				VEW	PANE	 	)			
			LO	AD		LO.	AD			
NOTES	DESCRIPTION	P - AMP	LIGHTING	POWER	PH / CKT #	POWER	LIGHTING	P - AMP	DESCRIPTION	NOTES
	Stage Receptacle	1 - 20		1200	1 A 2	1200		1 - 20	Stage Receptacle	
	Stage Receptacle	1 - 20		1200	3 B 4	1200		1 - 20	Stage Receptacle	
	Festoon Lights	1 - 20		300	5 C 6		300	1 - 20	Festoon Lights	
	Space Only	1			7 A 8			1	Space Only	
	Space Only	1			9 B 10			1	Space Only	
	Space Only	1			11 C 12			1	Space Only	
LOAD S	BUMMARY			CONN. KW	N.E.C. DIV.	DIY. Kw				
LIGHTING 0.6				0.6	× 1.25	0.8	POLES		12	
POWER	POWER 4.8				× 1.0	4.8	SIZE		10A. AMP	
OTHER	OTHER 0.0			0.0	× 1.0	0.0	MAINS	6	O AMP M.C.B.	
							∨OLTS	120	0/208√., 3¢, 4W	
							A.I.C.		10K	
							MOUNTING	<b>3</b>	Surface	
							ENCL <i>OS</i> U	IRE	NEMA 3R	
	TOTALS			5.4		5.6				
PROJECT Downtown Rockwall Streetscape - Phase 2 Rockwall, Texas			NOTES:		PANEL AM	PS	15			
PANEL LOCATION: Back of Stage @ Pedestrian Mall						LOADS PE		2.4		
DATE: February 2014				1		PHASE B		2.4		
		J = -					PHASE C		0.6	

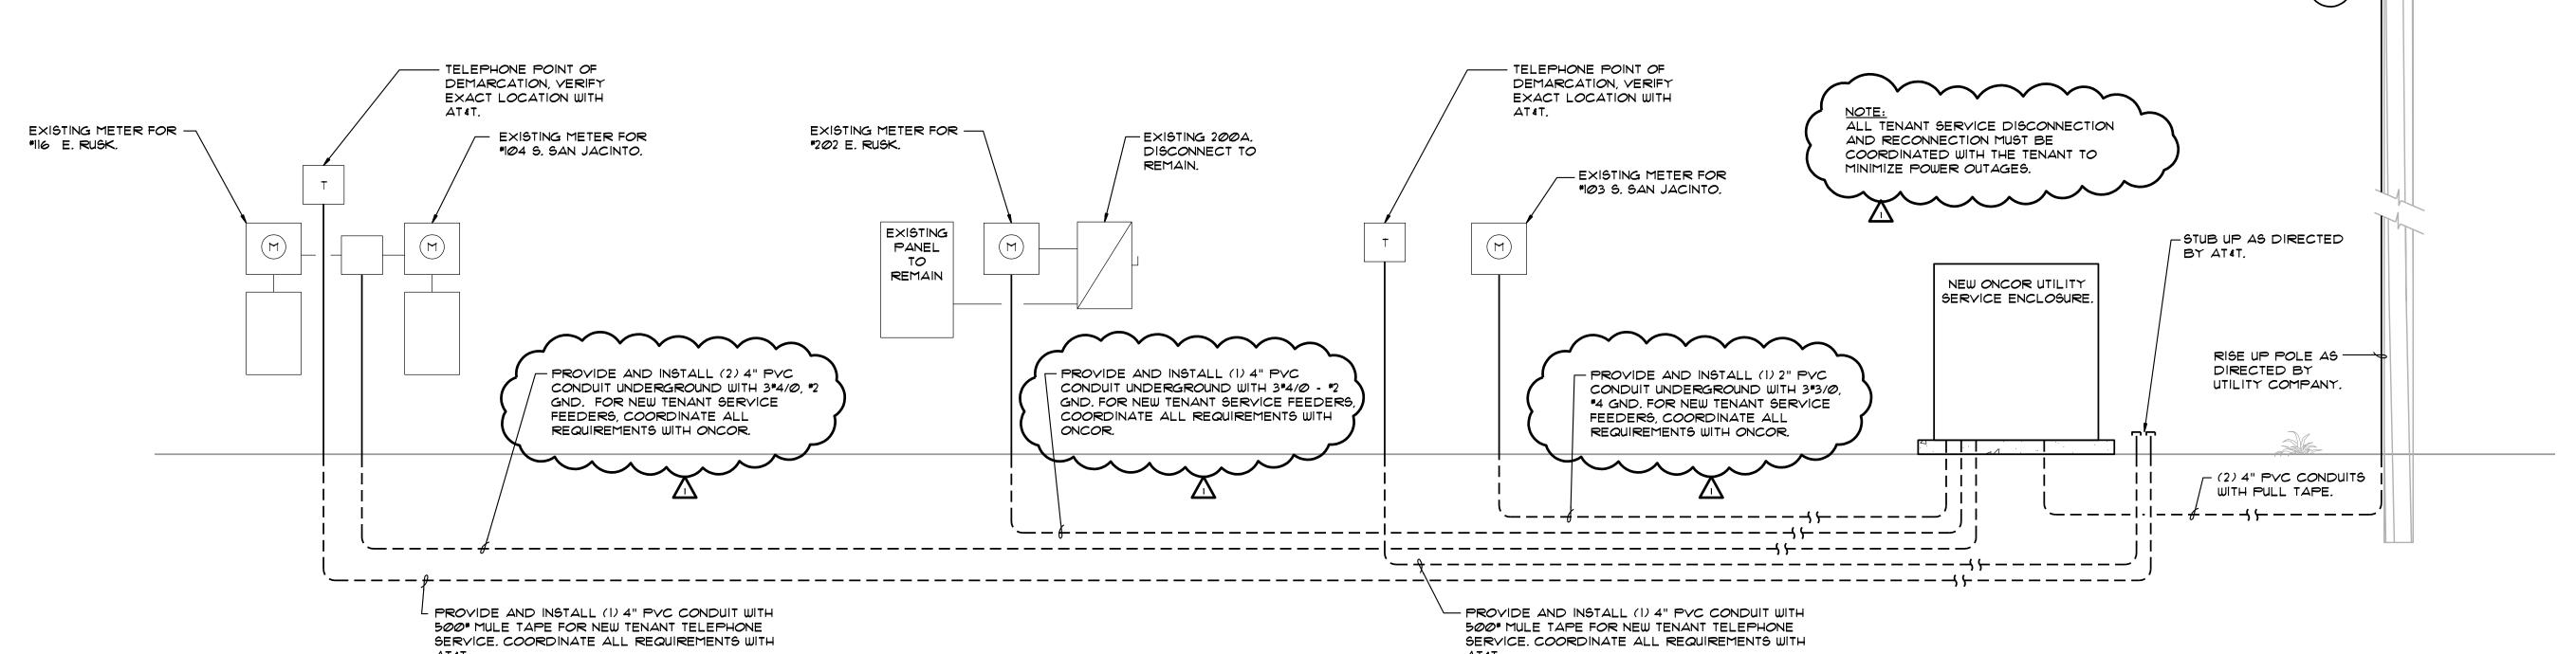


TENANT ELECTRICAL SERVICE RISER DIAGRAM
SCALE: NONE



Pacheco Koch
DALLAS - FORT WORTH - HOUSTON



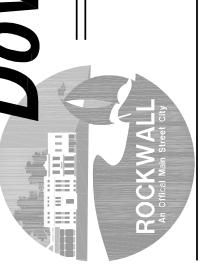


no.	<u>date</u>	detail				
$\overline{\Delta}$	4/2/2014	Electrical Revisions				

la terra studio, inc. 12024 Its project number 02.26.2014

drawn by

TX REG #F-4925 Ph: 940 . 427 . 8487 Fax: 940 . 427 . 8499 P.O. Box 167 Alvord, TX 76225 checked by

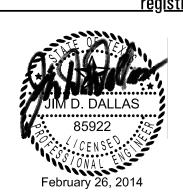

Electrical Details & Scheds. - Phase 2