



- 1) FINISH GRADE AT 1" BELOW TOP OF BOX IN TURF AREAS: 2" BELOW TOP OF BOX IN SHRUB/GROUNDCOVER 9" ROUND VALVE BOX WITH LOCKABLE LID
- 3 EXTENSION SECTION AS NECESSARY TO MEET GRADE
- 4 PVC MALE ADAPTER
- (5) 3-INCH MINIMUM DEPTH OF $\frac{3}{4}$ -INCH WASHED GRAVEL
- (6) BRASS BALL VALVE (SIZED PER MAINLINE)
- (7) IRRIGATION MAINLINE

BRASS BALL VALVE

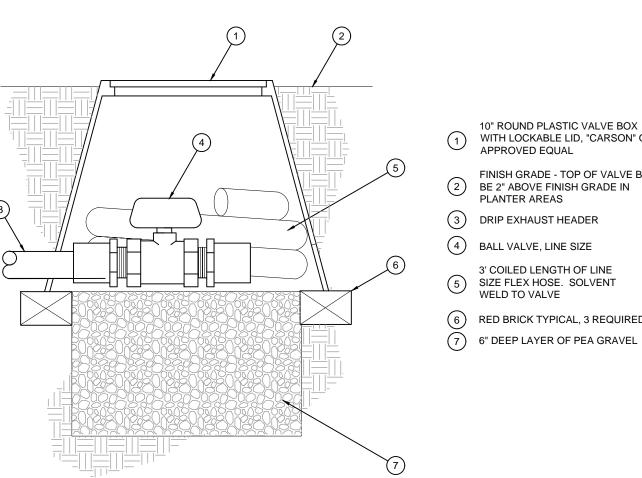


FLUSH VALVE
SCALE: NTS

- 10" ROUND PLASTIC VALVE BOX
 WITH LOCKABLE LID, "CARSON" OR APPROVED EQUAL
- FINISH GRADE TOP OF VALVE BOX TO
 BE 2" ABOVE FINISH GRADE IN PLANTER AREAS
- 3 DRIP EXHAUST HEADER 4 BALL VALVE, LINE SIZE
- 3' COILED LENGTH OF LINE
 SIZE FLEX HOSE. SOLVENT
- WELD TO VALVE (6) RED BRICK TYPICAL, 3 REQUIRED

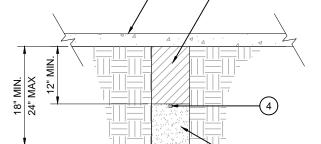

TRENCHING

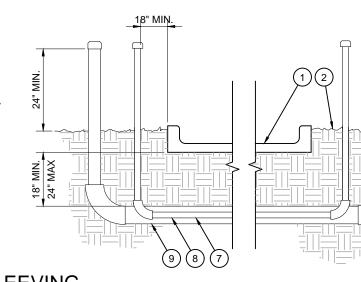

PAVEMENT SURFACE

(3) TRENCH BACKFILL

(6) SAND BACKFILL

(5) PVC IRRIGATION LATERAL

(10) PVC IRRIGATION MAINLINE

(12) PVC CAP, SOLVENT WELDED

4) LOCATOR WIRE W/BURIED CAUTION TAPE

(7) SCH. 40 PVC LATERAL SLEEVE - SEE PLANS FOR SIZE

(9) SCH. 40 PVC MAINLINE SLEEVE - SEE PLANS FOR SIZE


(11) CONTROL WIRES - TAPE TO MAINLINE AT 10' INTERVALS

8) SCH. 40 PVC WIRE SLEEVE FOR CONTROL WIRES, MIN. 2" DIA.


(2) FINISH GRADE

SLEEVING

PIPE AND SLEEVE INSTALLATION SCALE: NTS

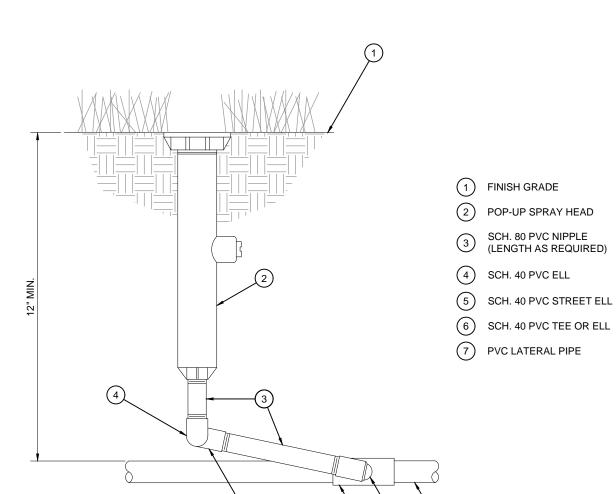

POP-UP SPRAY HEAD

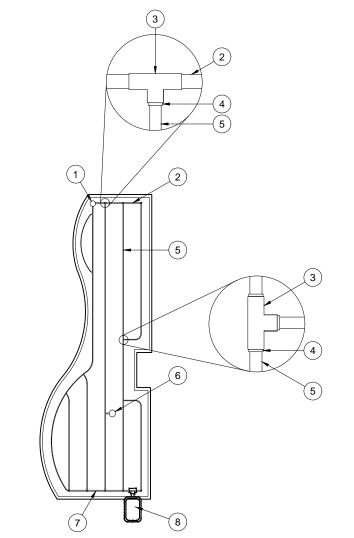

1 FLUSH VALVE (2) SCH. 40 PVC EXHAUST HEADER

SCH. 40 PVC TEE OR ELL

COMPRESSION ADAPTER DRIP LINE

AIR RELIEF VALVE AT HIGH POINT OF SYSTEM (WHERE INDICATED ON PLANS)

SCH. 40 PVC SUPPLY HEADER CONTROL VALVE

NOTE: SET DRIP LINES 3"-6" AWAY FROM

SUBSURFACE DRIP LINE LAYOUT SCALE: NOT TO SCALE




LAND S
SUSTAI

UPST

NEW I

BOST

NEW I

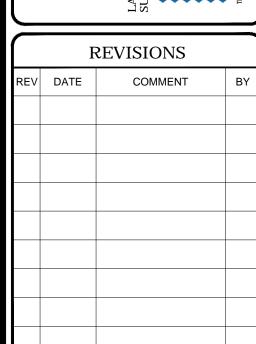



NOT APPROVED FOR CONSTRUCTION

It's fast. It's free. It's the law.

DRAWN BY: CHECKED BY: DATE: SCALE: CAD I.D.:

PROP. SITE PLAN **DOCUMENTS**

BRAKES PLUS

LOCATION OF SITE SW CORNER OF S. GOLIAD ST AND YELLOW JACKET LN LOTS 1 & 2, BLOCK A, BILLY PEOPLES ADDITION NO. 1 ROCKWALL, TX 75087 ROCKWALL COUNTY



6017 MAIN STREET FRISCO, TX 75034 Phone: (469) 458-7300 TX@BohlerEng.com



SHEET TITLE:

IRRIGATION DETAILS

SHEET NUMBER:

L-1.4

CASE NUMBER:

C:\USERS\CMROS\DROPBOX (RODNEY)\EDG - SHARED\2018\BRAKES PLUS - ROCKWALL TX\BRAKES PLUS ROCKWALL IRRG.DWG PRINTED BY: CMROS 2.01.19 @ 9:52 AM LAST SAVED BY: CMROS